


REVISIONS		DDC. NO. SPC-FD05, Total Pages: 2		Effective: 7/15/97, DCP No: 229		Supersedes DCP No: 103			
DCP #	REV	DESCRIPTION		DRAWN	DATE	CHECKD	APPROV'D	DATE	
09	A	RELEASED		J.W.M.	10/8/97	J.C.	10/27/97	B.B.	11/4/97
421	B	Electronic file name changed		J.W.M.	2/5/98	J.C.	2/5/98	J.C.	2/5/98

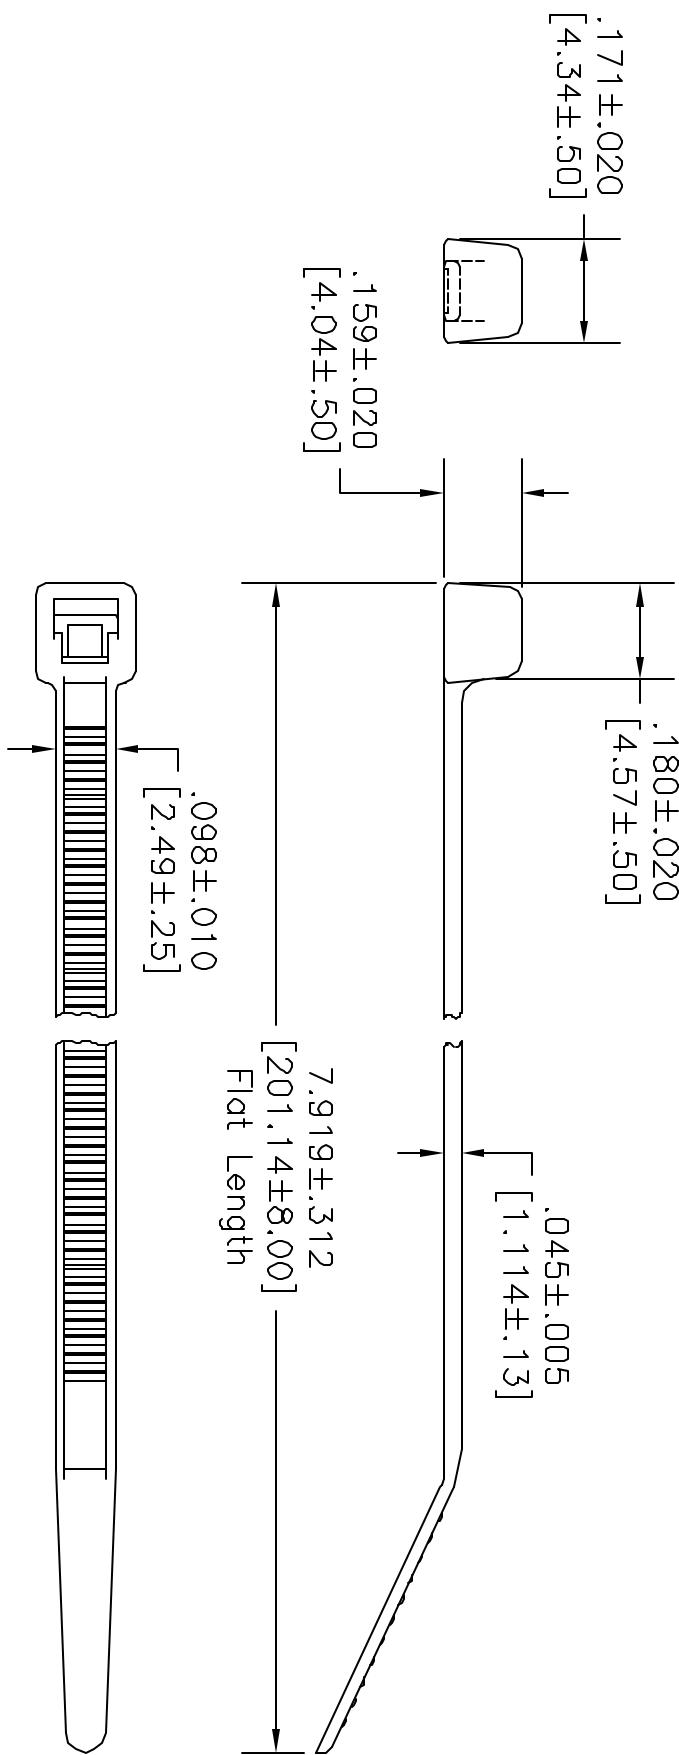

NOTES:

Material: Nylon 6/6-HSO
 Color: Black
 Packed: 100 to Bag
 Max. Bundle Dia: 2.000 [50.80]
 Min. Bundle Dia: .063 [1.59]
 Min. Loop Tensile Strength: 18 lbs.

DISCLAIMER
 ALL STATEMENTS AND TECHNICAL INFORMATION CONTAINED HEREIN ARE BASED UPON INFORMATION AND/OR TESTS WE BELIEVE TO BE ACCURATE AND RELIABLE. SINCE CONDITIONS OF USE ARE BEYOND OUR CONTROL, THE USER SHALL DETERMINE THE SUITABILITY OF THE PRODUCT FOR THE INTENDED USE AND ASSUME ALL RISK AND LIABILITY WHATSOEVER IN CONNECTION THEREWITH.



SPC TECHNOLOGY
 6000 11th Street, Suite 400, Fort Collins, CO 80524, U.S.A.
 970-226-4444

Unless otherwise specified, dimensions are shown for reference only. Your own tests will determine the suitability of this product for your application.		DRAWN BY: Jeff McVicker DATE: 10/8/97		DRAWING TITLE: Cable Tie - Heat Stabilized		CHECKED BY: JOHN COLE DATE: 10/24/97		SIZE: A DWG. NO.: 8409-0372		ELECTRONIC FILE NAME: 16N862.dwg		REV: B
APPROVED BY: BRETT BRAATZ DATE: 11/4/97		SCALE: NTS		U.O.M.: INCHES [mm]		SHEET: 1 OF 1						