


ALL RIGHTS RESERVED. NO PORTION OF THIS PUBLICATION, WHETHER IN WHOLE OR IN PART CAN BE REPRODUCED WITHOUT THE EXPRESS WRITTEN CONSENT OF SPC TECHNOLOGY.

REVISIONS			DDC. NO. SPC-F004 * Effective: 12/21/98 * DCP No: 680					
DCP #	REV	DESCRIPTION	DRAWN	DATE	CHECKD	DATE	APPRVD	DATE
1979	A	RELEASED	JWM	2/14/00	JN	03/17/08	JN	03/17/08

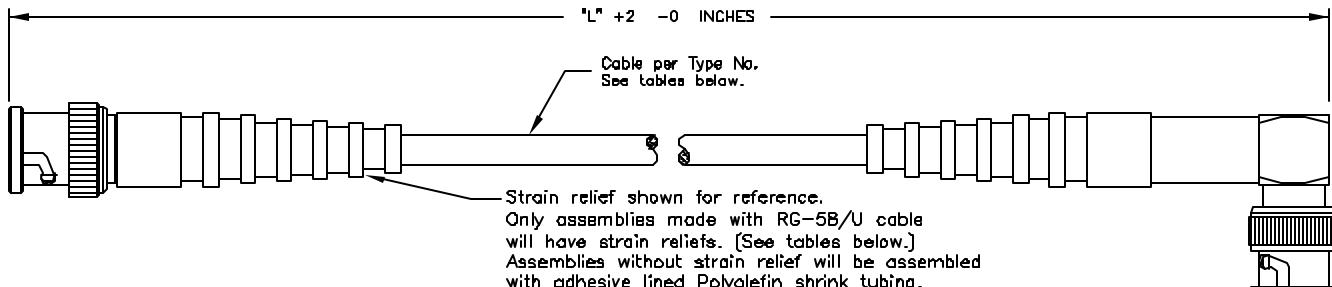

RFW-5000-XX
[L] LENGTH IN INCHES
SPECIFIC PART NUMBER
CABLE ASSEMBLY DESIGNATOR

SPC #	Cable Type	Length	Strain Relief
SPC20685	RG-59B/U	24	No
SPC20686	RG-59B/U	72	No
SPC20687	RG-58A/U	12	Yes
SPC20688	RG-58A/U	24	Yes
SPC20689	RG-58A/U	36	Yes
SPC20690	RG-58A/U	48	Yes
SPC20691	RG-58A/U	72	Yes
SPC20692	RG-58C/U	36	No
SPC20693	RG-58C/U	72	No
SPC20753	LMR-195	60	No
SPC20754	LMR-196	72	No



SPC-F004.DWG

DISCLAIMER:
ALL STATEMENTS AND TECHNICAL INFORMATION CONTAINED HEREIN ARE BASED UPON INFORMATION AND/OR TESTS WE BELIEVE TO BE ACCURATE AND RELIABLE. SINCE CONDITIONS OF USE ARE BEYOND OUR CONTROL, THE USER SHALL DETERMINE THE SUITABILITY OF THE PRODUCT FOR THE INTENDED USE AND ASSUME ALL RISK AND LIABILITY WHATSOEVER IN CONNECTION THEREWITH.



SPC TECHNOLOGY

UNLESS OTHERWISE SPECIFIED, DIMENSIONS ARE FOR REFERENCE PURPOSES ONLY.	DRAWN BY:	DATE:	DRAWING TITLE: CABLE ASSEMBLY			
	Jeff McVicker	2/14/00	BNC MALE CRIMP TO BNC MALE CRIMP R/A			
	CHECKED BY:	DATE:	SIZE	DWG. NO.	ELECTRONIC FILE	
	Jason Nash	03/17/08	A	TA-843	TA-843.DWG	
	APPROVED BY:	DATE:	REV			
	Jason Nash	03/17/08	SCALE: NTS	U.O.M.: INCHES [mm]	A	
SHEET: 1 OF 1						